

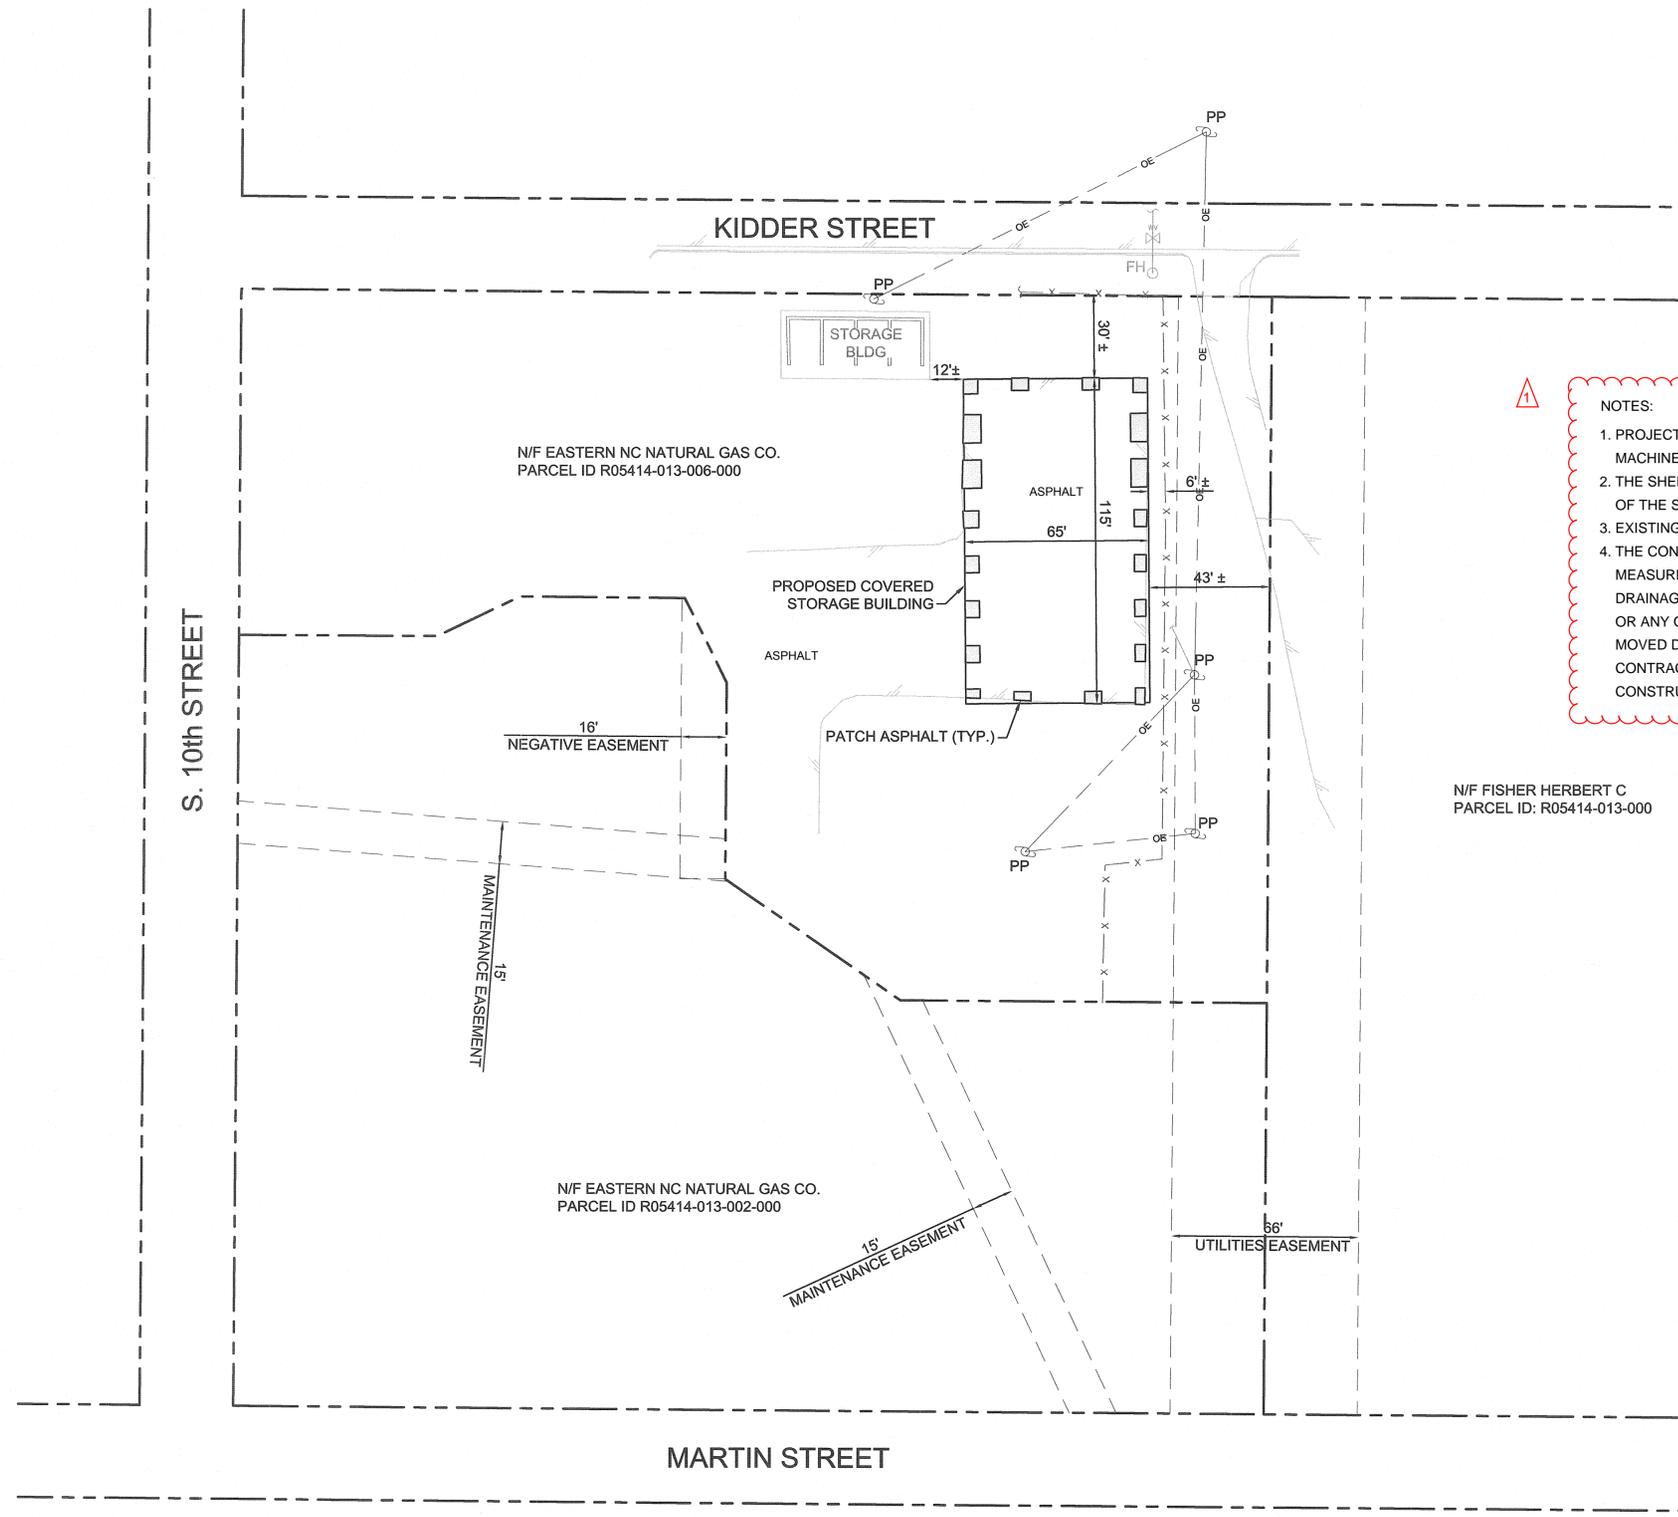


PATH: P:\275\275-74 PED NATURAL GAS PEIMB\DWG\MASTER_275-74.DWG

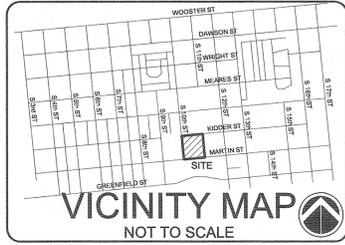

- NOTES:**
1. PROJECT CONSISTS OF ERECTION OF A PRE-ENGINEERED MACHINERY SHELTER.
 2. THE SHELTER DOES NOT INCREASE NET IMPERVIOUS SURFACE OF THE SITE.
 3. EXISTING DRAINAGE SHALL REMIAN AS IS.
 4. THE CONTRACTOR SHALL TAKE ADEQUATE PROTECTIVE MEASURES TO INSURE THAT EXISTING PAVEMENT SURFACES OR DRAINAGE STRUCTURES ARE NOT DAMAGMED FROM EQUIPMENT OR ANY OTHER POSSIBLE SOURCE WHEN EQUIPMENT IS BEING MOVED DURING OR AFTER WORK IS BEING CONDUCTED. THE CONTRACTOR SHALL REPAIR ANY PAVED AREAS DAMAGED DURING CONSTRUCTION.

FINAL DESIGN FOR PERMITTING

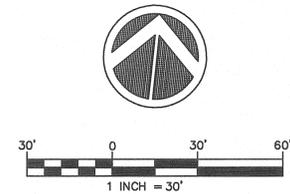

NOTES:
SEE SHEET I-1 FOR GENERAL NOTES AND LEGEND.



1. NOTES FOR DRAINAGE PLAN 9/15/16

REV. #	DESCRIPTION	REV. BY	DATE
B	FINAL DESIGN FOR PERMITTING	MTH	8/12/16
A	ISSUED FOR CLIENT REVIEW	MTH	8/01/16



CAPE FEAR ENGINEERING
 151 Poole Rd., Suite 100; Belville, NC, 28451
 TEL (910) 383-1044; FAX (910) 383-1045
 www.capefearengineering.com
 N.C. LICENSE # C-1621

PROJECT NUMBER : 275-74
 SCALE : 1"=30'
 DATE : 29 JUL 16
 TRACKING : LMN

PIEDMONT NATURAL GAS COVERED STORAGE BUILDING

SITE PLAN

PROJECT NUMBER: 275-74 SHEET NUMBER: C-2